 


Appendix D Drainage Strategy Drawings



NOTES:

1. ALL LEVELS ARE APPROXIMATE. DETAILED LEVELS ANALYSIS IS REQUIRED
2. GROUND LEVELS OUTSIDE OF THE BUILDING ARE ASSUMED TO BE 150mm BELOW FFL
3. FFL LEVELS ARE TO BE CONFIRMED
4. ATTENUATION & FOUL WATER PIPE & GULLY LOCATIONS ARE INDICATIVE. FINAL LOCATIONS TO BE CONFIRMED
5. INLETS & OUTLETS TO SWALES WILL REQUIRE HEADWALLS. 1500 CONNECTIONS CAN BE ACO SuDS INLET

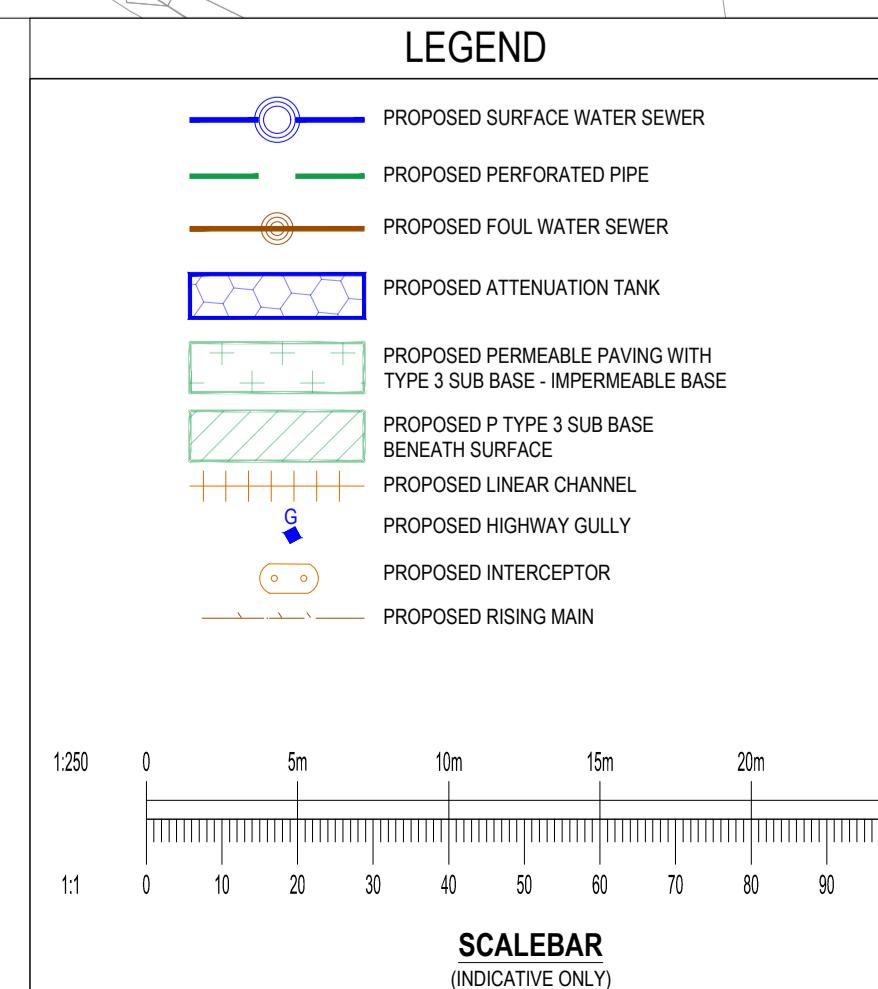

DRAINAGE STRATEGY:

SURFACE WATER RUN OFF ENTERS THE SYSTEM VIA A NUMBER OF GULLIES, RAIN WATER PIPES AND PERMEABLE SURFACES. THIS THEN FALLS VIA GRAVITY THROUGH A FLOW CONTROL WHERE THE FLOWS ARE RESTRICTED TO GREENFIELD RATES (25l/s).

1. THIS DRAWING IS TO BE READ IN CONJUNCTION WITH ALL RELEVANT ARCHITECTS AND ENGINEERS DRAWINGS AND SPECIFICATIONS
2. DO NOT SCALE THIS DRAWING. ANY AMBIGUITIES, OMISSIONS AND ERRORS ON DRAWINGS SHALL BE BROUGHT TO THE ENGINEERS ATTENTION IMMEDIATELY. ALL DIMENSIONS MUST BE CHECKED / VERIFIED ON SITE.
3. ALL DIMENSIONS ARE IN MILLIMETRES UNLESS NOTED OTHERWISE.
4. FOR GENERAL NOTES REFER TO DRAWING.


ISSUED FOR INFORMATION S2

Client: MONTE BLACKBURN LTD.


Project: JUNCTION 11, BANBURY

UNIT C DRAINAGE LAYOUT

Project No:	Size:	Date:	Drawn By:	Designed By:	Checked By:
072305	A0	JUL 2021	DM	DM	CS
Project Code:	Originator:	Zone:	Level:	Type:	Discipline:
072305 - CUR - XX - XX - DR - C - 92101	P01	FIRST ISSUE	08/07/2021	DM	CS

 


Status:		ISSUED FOR INFORMATION		S2
Client:		MONTE BLACKBURN LTD.		
Project:		JUNCTION 11, BANBURY		
Dwg Title:		UNIT C IMPERMEABLE AREAS PLAN		
P01	FIRST ISSUE	08/07/2021	DM	CS
Rev:	Description:	Date:	By:	Chkd:
c-curtins <small>Units 24 & 25 Riverside Place, K Village, Lound Road, Kendal, LA8 1FH 01539 724825 info@curtins.com www.curtins.com</small>				
Project No:		Size:	Drawn By:	Designed By:
072305		A0	JUL 2021	DM DM CS
Project Code:		Originator:	Zone:	Level Type Discipline Category / Number
072305 - CUR - XX - XX - DR - C - 92102				

 

GENERAL NOTES:							Status: ISSUED FOR INFORMATION	S2																	
<ol style="list-style-type: none"> 1. THIS DRAWING IS TO BE READ IN CONJUNCTION WITH ALL RELEVANT ARCHITECTS AND ENGINEERS DRAWINGS AND SPECIFICATIONS. 2. DO NOT SCALE THIS DRAWING. ANY AMBIGUITIES, OMISSIONS AND ERRORS ON DRAWINGS SHALL BE BROUGHT TO THE ENGINEERS ATTENTION IMMEDIATELY. ALL DIMENSIONS MUST BE CHECKED / VERIFIED ON SITE. 3. ALL DIMENSIONS ARE IN MILLIMETRES UNLESS NOTED OTHERWISE. 4. FOR GENERAL NOTES REFER TO DRAWING. 5. THE FLOODING LOCATION ARE WHERE IT IS LIKELY THAT THE SURFACE WATER WILL APPEAR FROM - THIS IS BASED ON TESTING THE DRAINAGE MODEL TO FAILURE. THESE FLOOD EVENTS WILL HAPPEN FOR STORM EVENTS ABOVE THE 1 IN 100YR + 40% CLIMATE CHANGE EVENT AND IF A BLOCKAGE OCCURS. 							Client: MONTE BLACKBURN LTD.																		
							Project: JUNCTION 11, BANBURY																		
							Drg Title: UNIT C EXCEEDANCE FLOWS																		
<table border="1"> <tr> <td>P01</td> <td>FIRST ISSUE</td> <td>08/07/2021</td> <td>DM</td> <td>CS</td> </tr> <tr> <td>Rev:</td> <td>Description:</td> <td>Date:</td> <td>By:</td> <td>Chkd:</td> </tr> </table>		P01	FIRST ISSUE	08/07/2021	DM	CS	Rev:	Description:	Date:	By:	Chkd:														
P01	FIRST ISSUE	08/07/2021	DM	CS																					
Rev:	Description:	Date:	By:	Chkd:																					
 <p>Units 24 & 25 Riverside Place, K Village, Lound Road, Kendal, LA9 7FH 01539 724823 kendal@curtins.com</p>							<table border="1"> <tr> <td>Project No:</td> <td>Size:</td> <td>Date:</td> <td>Drawn By:</td> <td>Designed By:</td> <td>Checked By:</td> </tr> <tr> <td>072305</td> <td>A0</td> <td>JUL 2021</td> <td>DM</td> <td>DM</td> <td>CS</td> </tr> <tr> <td colspan="3">Scale: 1:250</td> <td colspan="3"></td> </tr> </table>	Project No:	Size:	Date:	Drawn By:	Designed By:	Checked By:	072305	A0	JUL 2021	DM	DM	CS	Scale: 1:250					
Project No:	Size:	Date:	Drawn By:	Designed By:	Checked By:																				
072305	A0	JUL 2021	DM	DM	CS																				
Scale: 1:250																									

 1. THIS DRAWING IS TO BE READ IN CONJUNCTION WITH ALL RELEVANT ARCHITECTS AND ENGINEERS DRAWINGS AND SPECIFICATIONS.
2. DO NOT SCALE THIS DRAWING, ANY AMBIGUITIES, OMISSIONS AND ERRORS ON DRAWINGS SHALL BE BROUGHT TO THE ENGINEERS ATTENTION IMMEDIATELY. ALL DIMENSIONS MUST BE CHECKED / VERIFIED ON SITE.
3. ALL DIMENSIONS ARE IN MILLIMETRES UNLESS NOTED OTHERWISE.



P01	INTERCEPTOR DETAIL ADDED	18/06/21	DM	PT
P01	FIRST ISSUE	28/05/21	DM	PT
Rev.	Description:	Date:	By:	Ordn.

c curtins
Units 2 & 2a Riverside Place, K Village, Round Road, Kendal, LA9 1FH
www.curtins.com
kendal@curtins.com

ISSUED FOR INFORMATION
S2

MONTE BLACKBURN LTD.

JUNCTION 11, BANBURY


UNIT C DRAINAGE DETAILS

Project No: 072305 **Size:** A0 **Date:** JUL 2021 **Drawn By:** DM **Designed By:** DM **Checked By:** Rev.

072305 - CUR - XX - XX - DR - C - 92104 - P01

Project Code: Originator: Zone: Level: Type: Discipline: Category: Number: Rev.

072305-CUR-XX-XX-DR-C-92104-P01

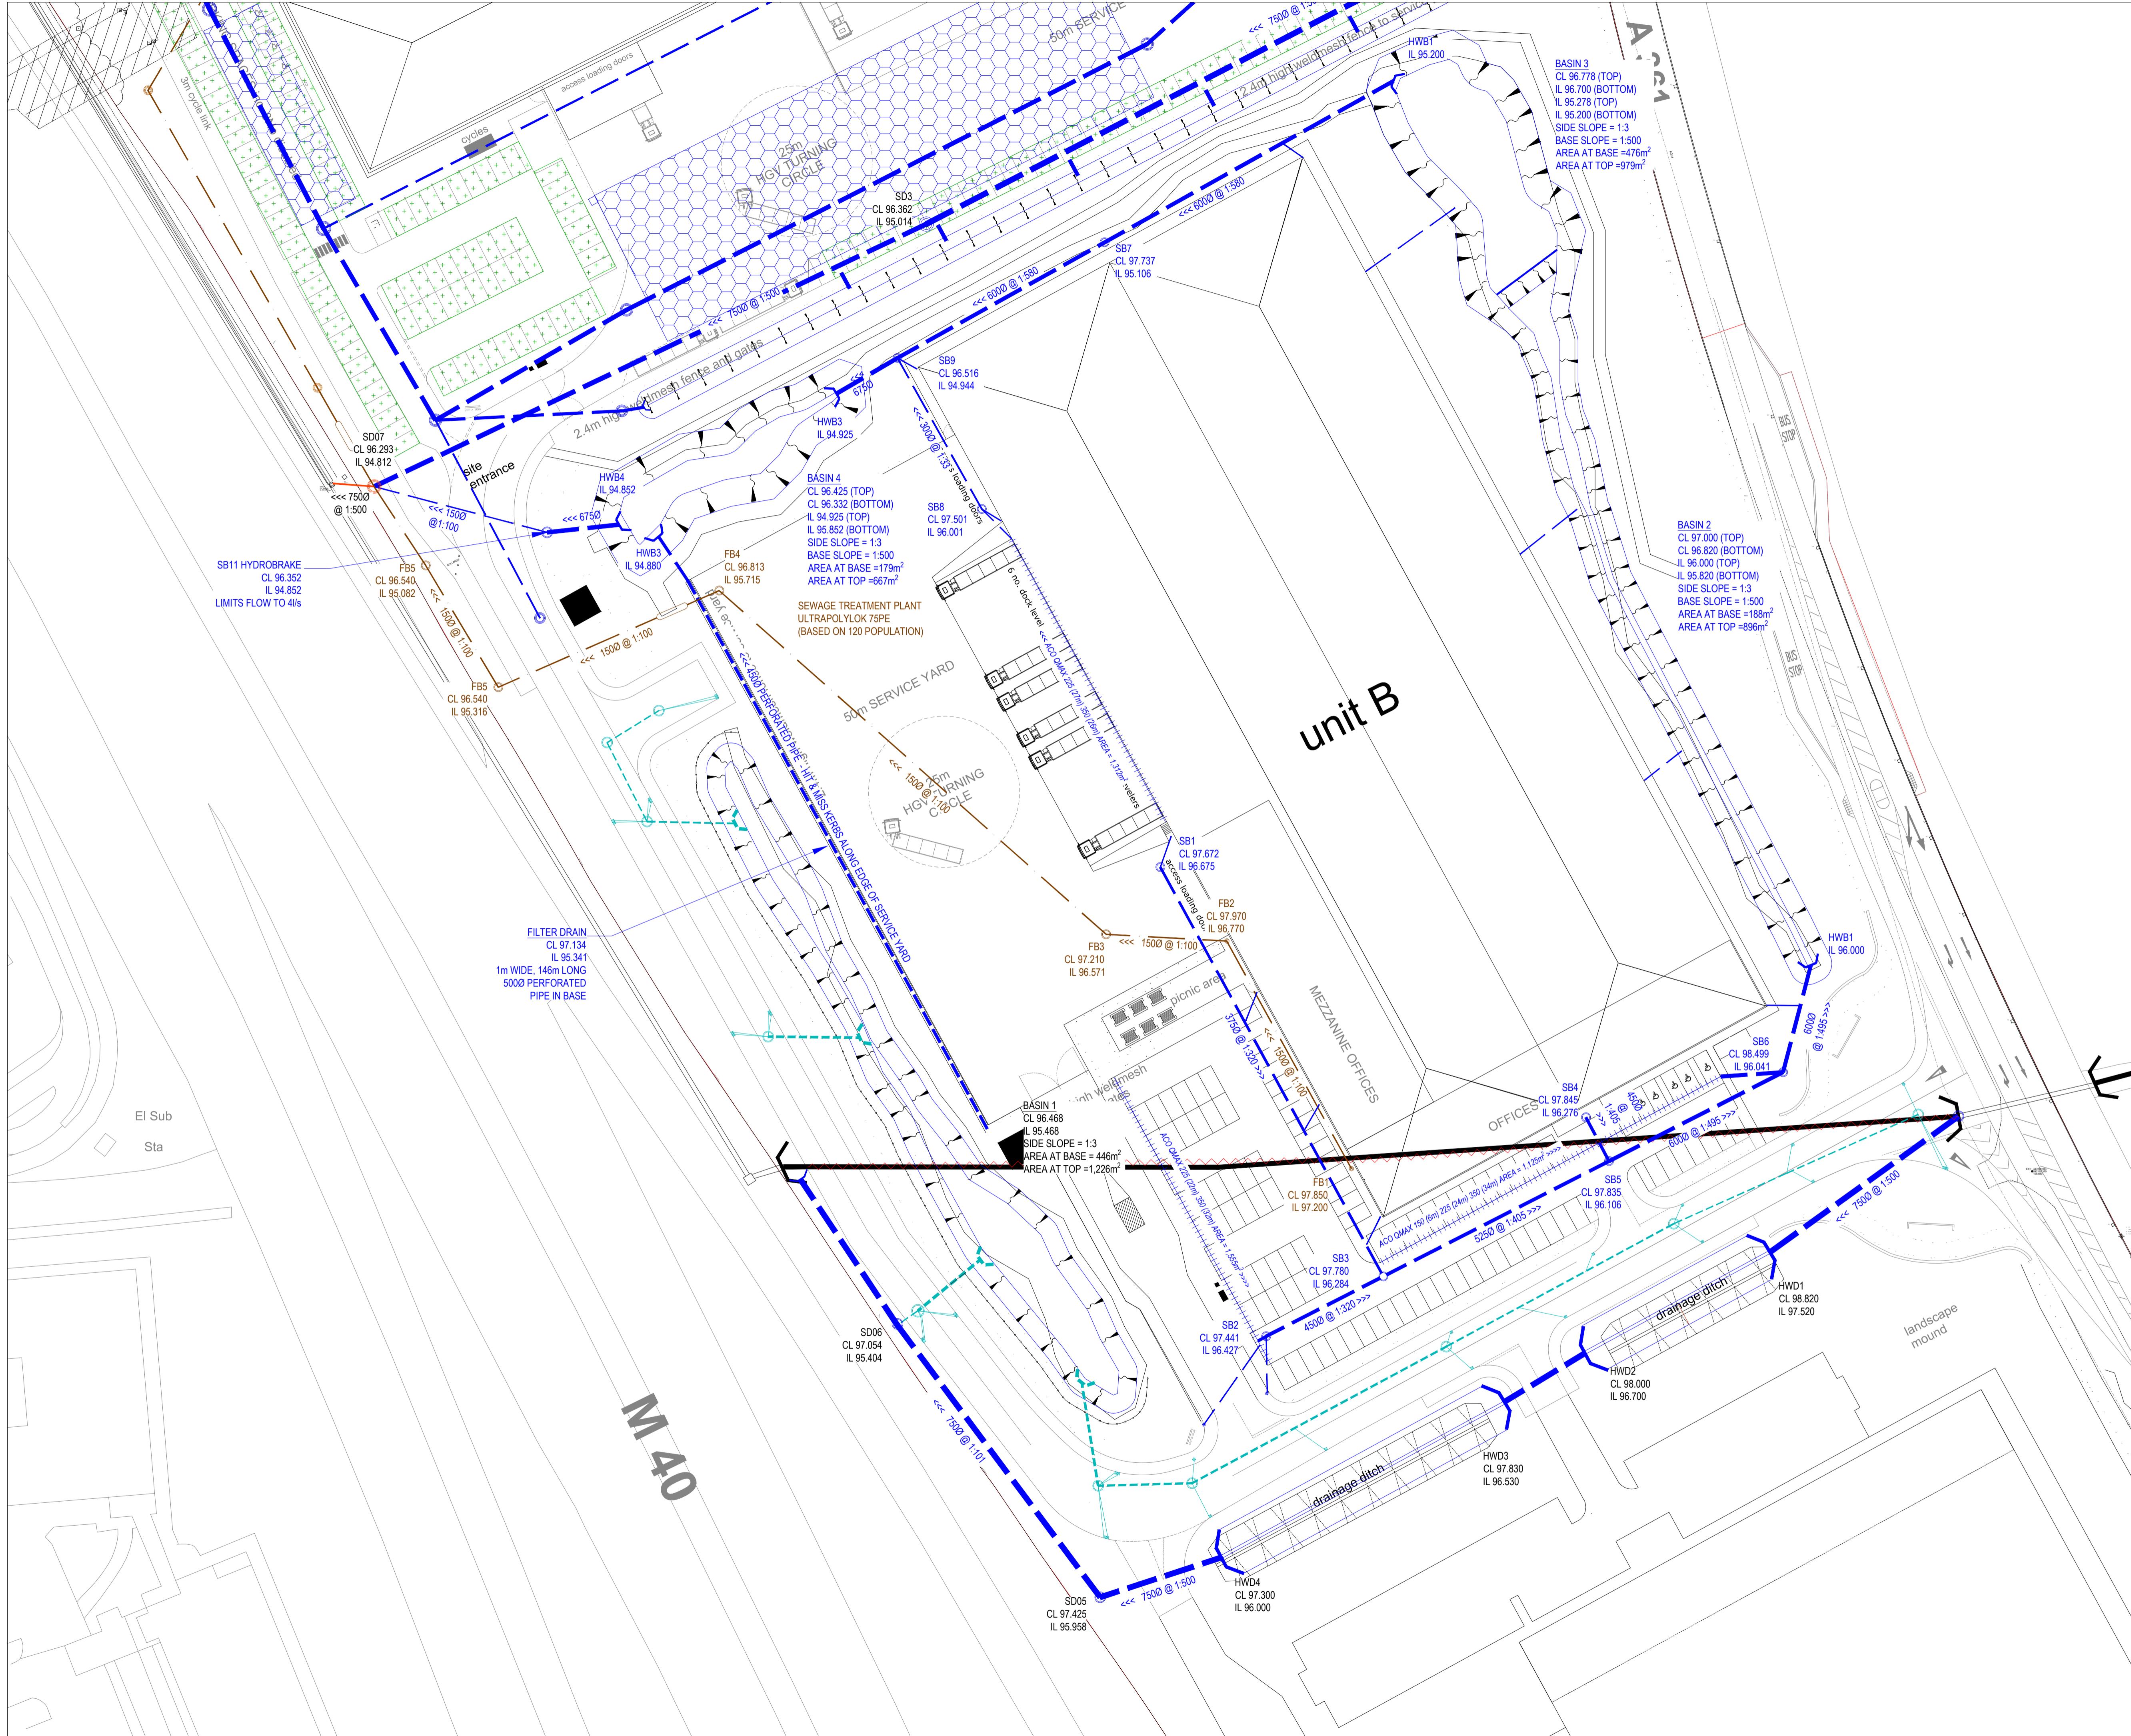

Our Locations

Birmingham
2 The Wharf
Bridge Street
Birmingham
B1 2JS
T. 0121 643 4694
birmingham@curtins.com

Bristol
Quayside
40-58 Hotwell Road
Bristol
BS8 4UQ
T. 0117 302 7560
bristol@curtins.com

Cambridge
50 Cambridge Place
Cambridge
CB2 1NS
T. 01223 631 799
cambridge@curtins.com

Cardiff
3 Cwrt-y-Parc
Earlswood Road
Cardiff
CF14 5GH
T. 029 2068 0900
cardiff@curtins.com

Douglas
Varley House
29-31 Duke Street
Douglas
Isle of Man
IM1 2AZ
T. 01624 624 585
douglas@curtins.com

Dublin
11 Pembroke Lane
Dublin 2
D02 CX82
Ireland
T. +353 1 507 9447
dublin@curtins.com

Edinburgh
1a Belford Road
Edinburgh
EH4 3BL
T. 0131 225 2175
edinburgh@curtins.com

Glasgow
Queens House
29 St Vincent Place
Glasgow
G1 2DT
T. 0141 319 8777
glasgow@curtins.com

Kendal
Units 24 & 25 Riverside Place
K Village
Lound Road
Kendal
LA9 7FH
T. 01539 724 823
kendal@curtins.com

Leeds
Ground Floor
Rose Wharf
78-80 East Street
Leeds
LS9 8EE
T. 0113 274 8509
leeds@curtins.com

Liverpool
51-55 Tithebarn Street
Liverpool
L2 2SB
T. 0151 726 2000
liverpool@curtins.com

London
40 Compton Street
London
EC1V 0BD
T. 020 7324 2240
london@curtins.com

Manchester
Merchant Exchange
17-19 Whitworth Street West
Manchester
M1 5WG
T. 0161 236 2394
manchester@curtins.com

Nottingham
56 The Ropewalk
Nottingham
NG1 5DW
T. 0115 941 5551
nottingham@curtins.com