

Proposed Adoptable Sewers:

9

_____ . _____ . _____

Adoptable Lateral

Adoptable Access Chamber

Proposed Private Drainage:



Linear: 0.0000

Private inspection chambers shall be non-access structural wall plastic. Chamber sizes to accord with manufacturers specifications, Building Regulations Part H, BS EN 752 and to NHBC Standards.

Invert levels shown thus: F10.00
S10.00


Externals:

Fall Arrows

Finished floor levels
shown thus: **FFL 10.00**

(Indicative FFLs, subject to detailed design and approval of highway levels).

Indicative street lighting column.

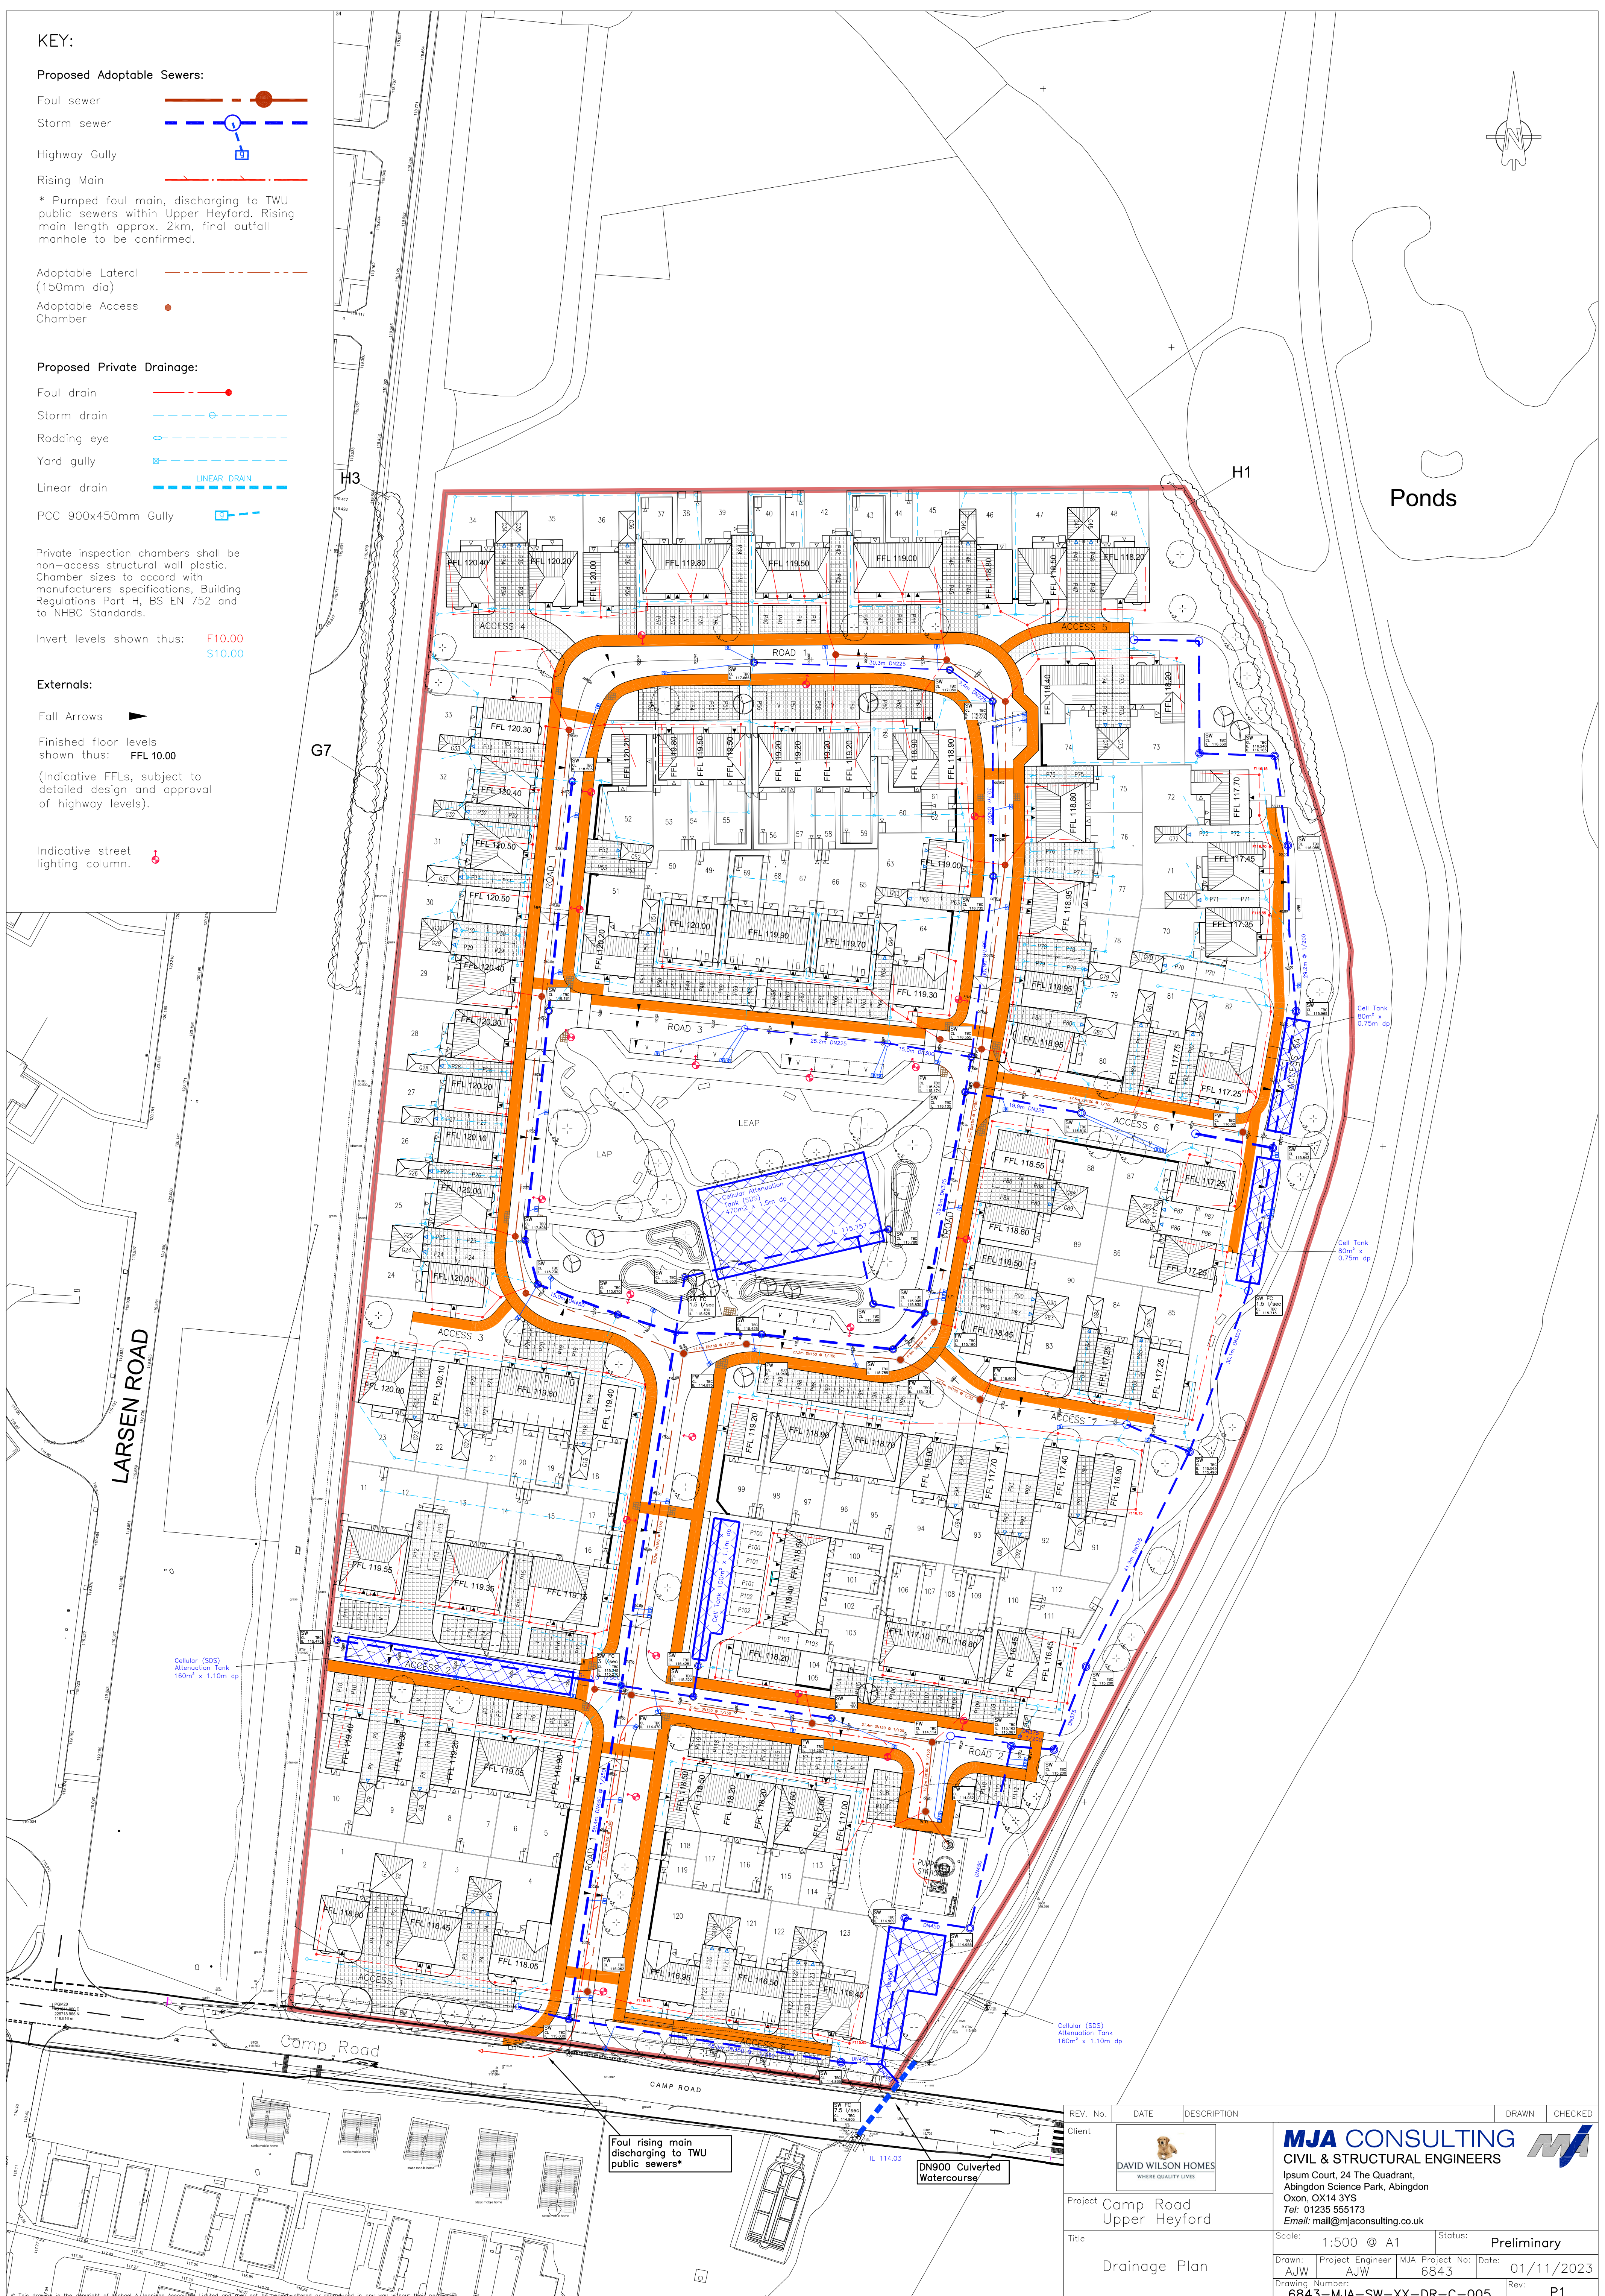

© This drawing is the copyright of Michael A. Jennings Associates, Limited and may not be copied, altered or reproduced in any way without their permission.

REV. No.	DATE	DESCRIPTION	DRAWN		CHECKED
Client					
Project	Camp Road Upper Heyford		MJA CONSULTING CIVIL & STRUCTURAL ENGINEERS Ipsum Court, 24 The Quadrant, Abingdon Science Park, Abingdon Oxon, OX14 3YS Tel: 01235 555173 Email: mail@mjaconsulting.co.uk		
Title	Drainage Plan		Scale:	1:500 @ A1	Status: Preliminary
			Drawn: AJW	Project Engineer: AJW	MJA Project No: 6843
			Date: 01/11/2023		
			Drawing Number: 6843-MJA-SW-XX-DR-C-005		Rev: P1