
Proposed Floor Plan

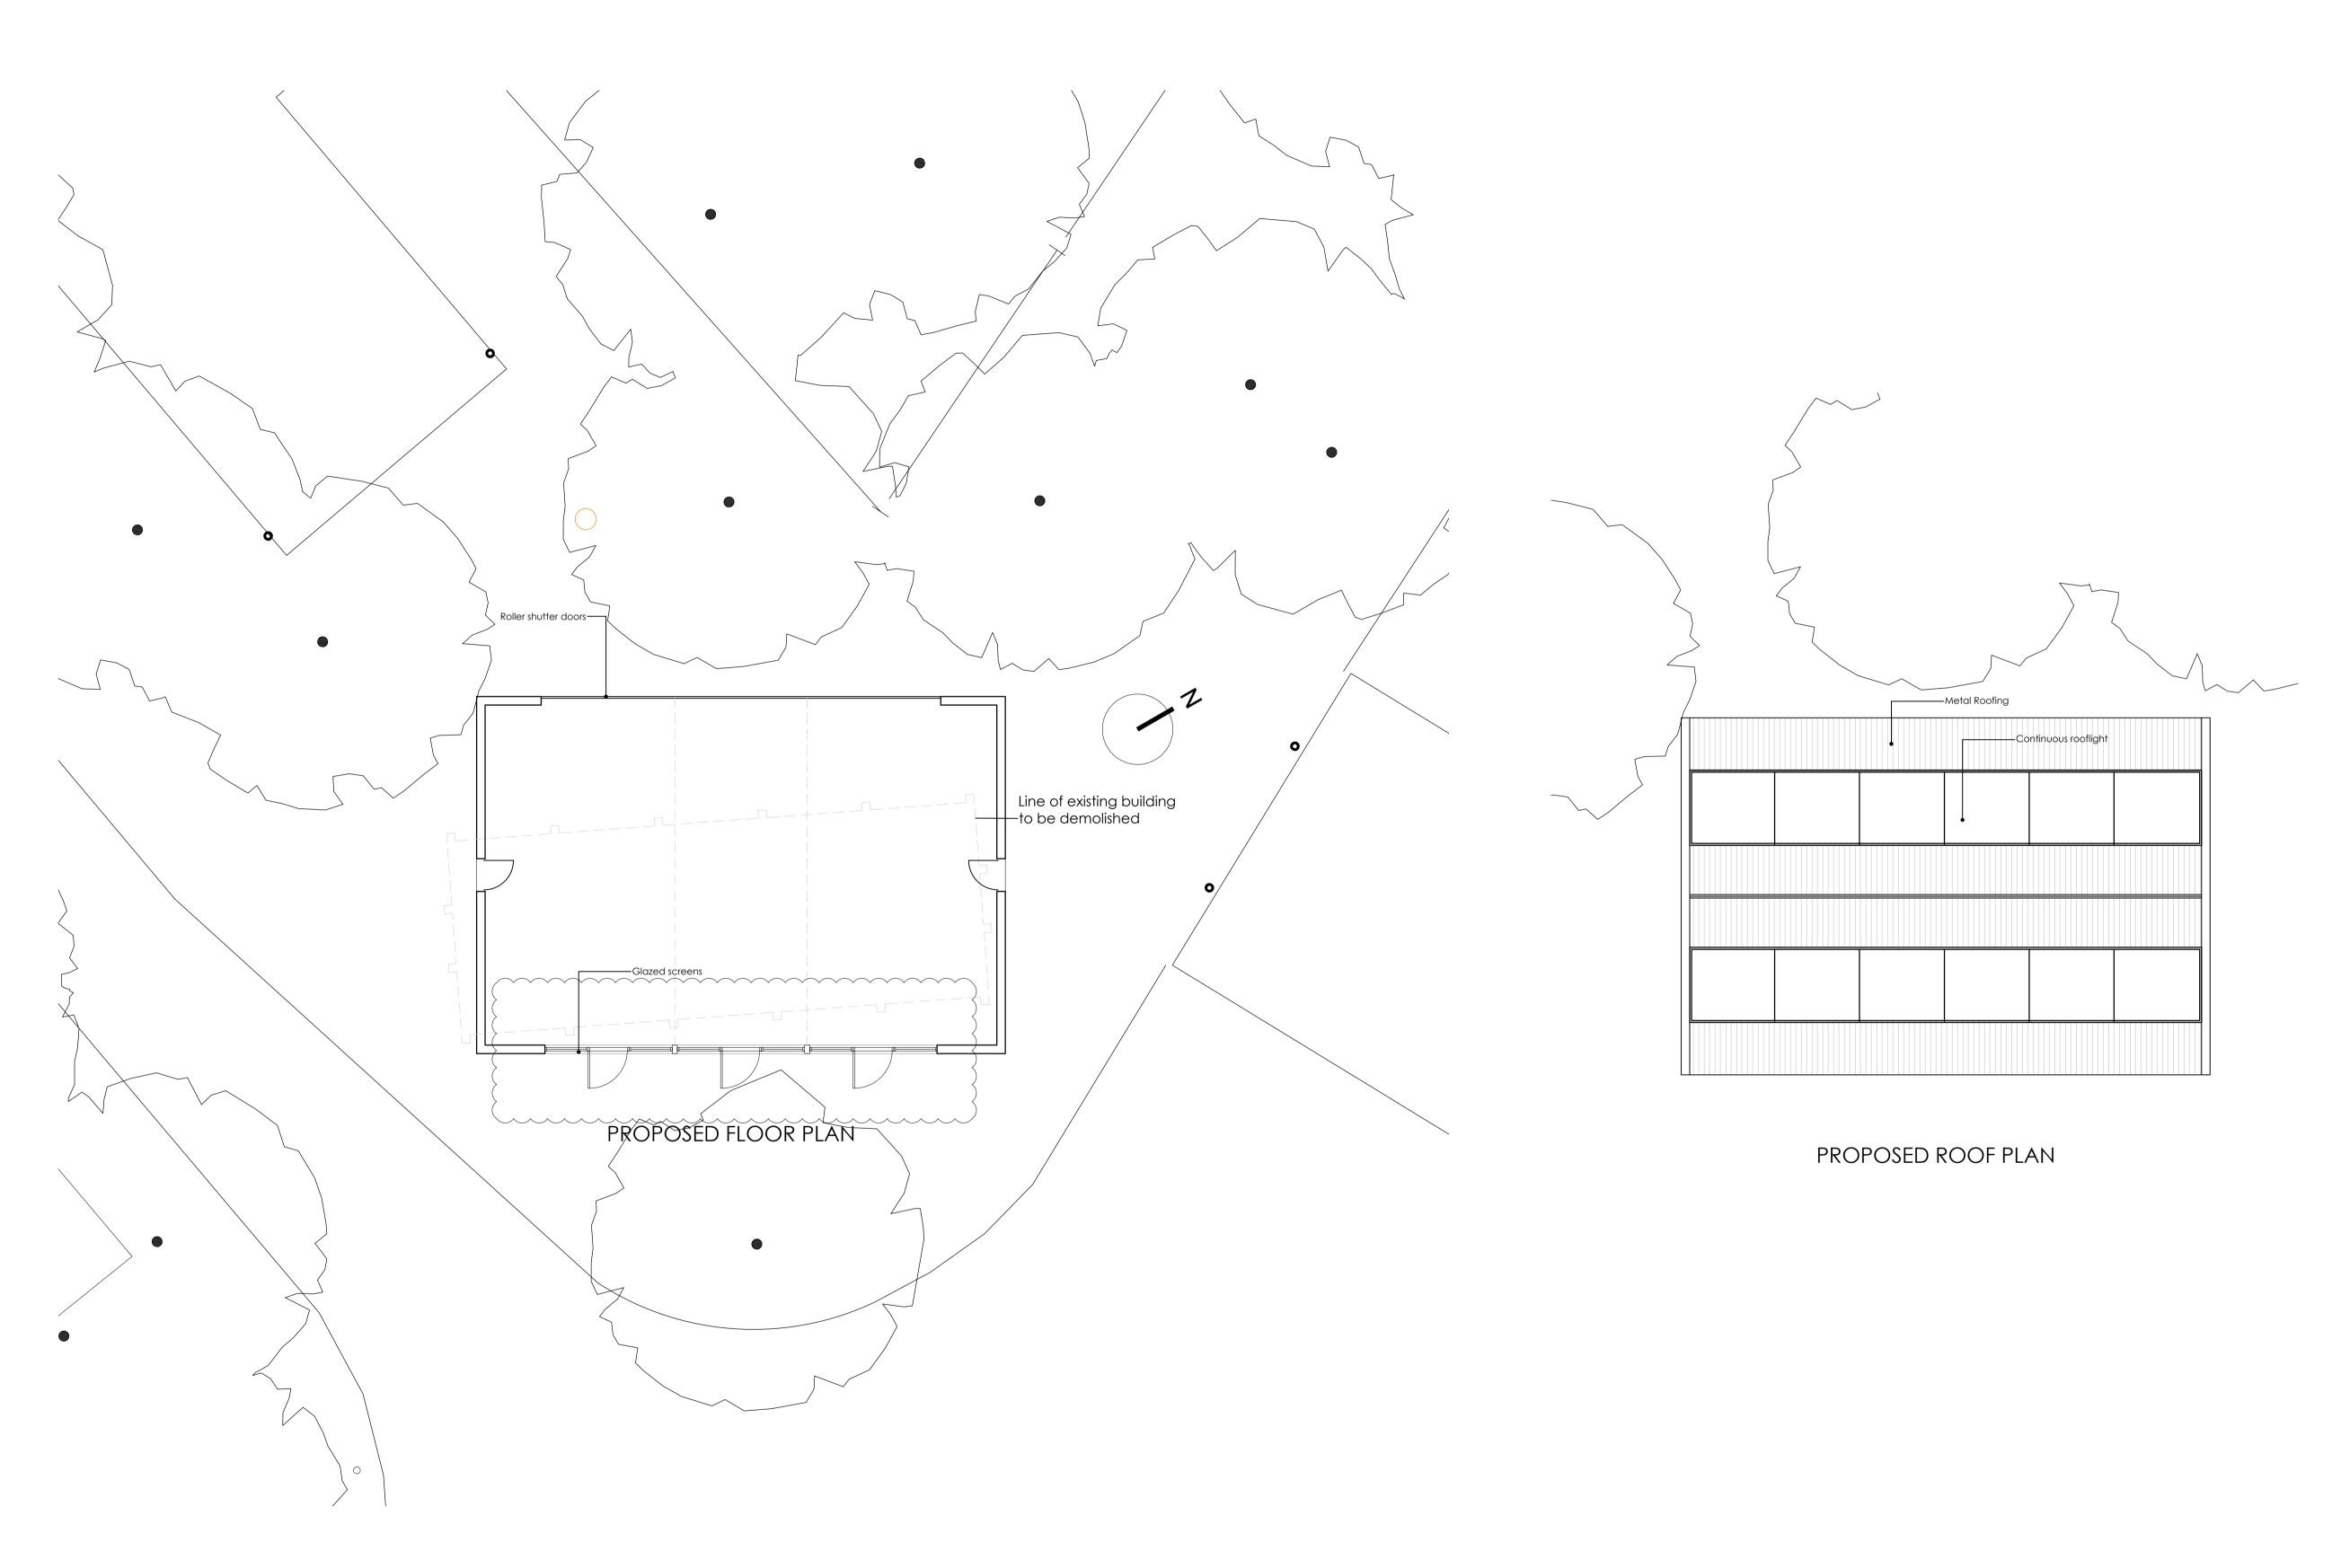

Planning

Bicester Herito	ge			
Project Bicester Airfiel	d			
Building 104				
Proposed Floc	or Pia	Ins		
Drawing No 12068 /104	Rev A	Drawn MH	Date	scale 1:200 @A1

